

MH 71-63907 TO MH 71-64900  
LINE 2703 LF OF 10 INCH VCP  
WITH CIPP LINER

MH 71-64900 TO MH 71-64901  
LINE 141 LF OF 12 INCH VCP  
WITH CIPP LINER

**811**  
Know what's below.  
Call before you dig.

REV.	DESCRIPTION	DATE	DRAWN	CHECKED

**CITY OF ANN ARBOR**  
PUBLIC SERVICE  
301 EAST HURON STREET  
ANN ARBOR MI 48106-1647  
www.a2gov.org

**PROJECT MANAGEMENT - PUBLIC SERVICES - CITY OF ANN ARBOR**  
2014 SEWER LINING PROJECT  
SOUTH STATE STREET CROSS LOTS




**SANITARY SEWER**

SHEET No. 30A OF 51

DRAWING No. 2013019-30A



S:\Project Management\Design\2013019 2014 Sewer Lining Project\Plan Production\Primary\2013019S3.dwg Dwg Created: 5-Feb-14 - \_o2 standard bw.stb - Plot Date: 30-Apr-14

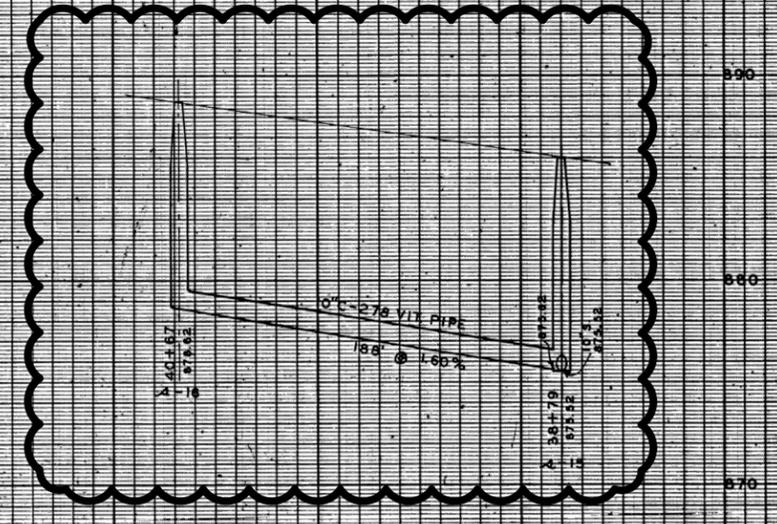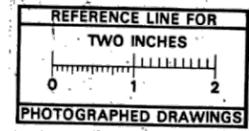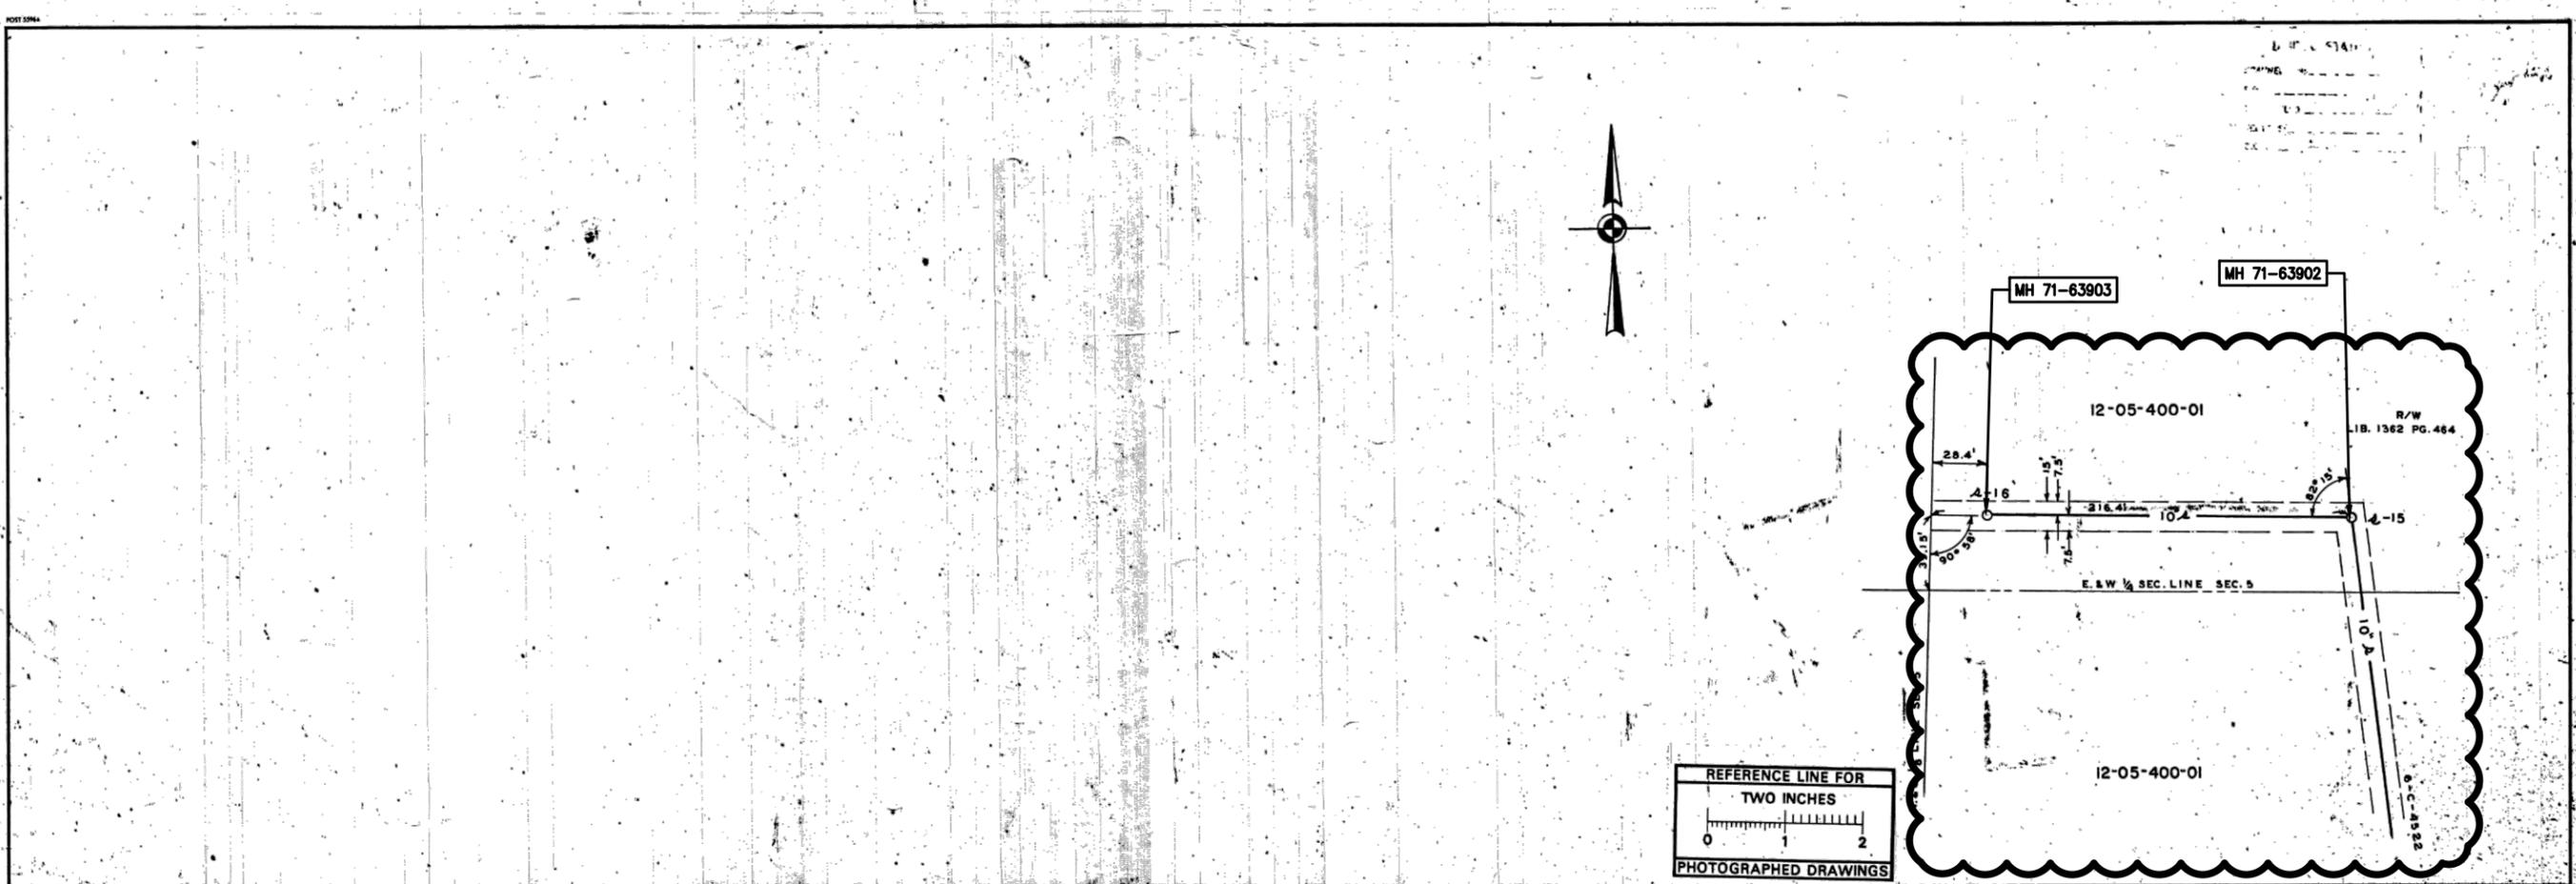

Digital Status  
 Scanned On: 6-15-05  
 By: DSK  
 Despeckled: YES  
 Vector:  
 O.C.R.:

DR. BY: OON	DATE: 12/89	SHEET NO.:	6646
TR. BY: L.F.S.	INDEX NO.:	SHELF NO.:	
CH. BY:	1/72		
REVISIONS:			
AS BLT. L.F.S.	2/72		
		6C - 4523 - S	
		SCALE: HORIZONTAL 1"=40'	
		VERTICAL 1"=4'	

SANITARY AND STORM SEWER  
**CROSSLOTS**  
 THRU EDWARDS BROTHERS TO  
 WEST LINE OF EDWARD BROTHERS  
 FREDRICK A. MAMMEL  
 SUPERINTENDENT OF PUBLIC WORKS

**LEGEND:**

—○—	EXISTING SANITARY	—○—	EXISTING STORM	—G—	EXISTING GAS
—●—	PROPOSED SANITARY	—●—	PROPOSED STORM	—W—	EXISTING WATER
—	CENTER LINE	---	RIGHT PROPERTY LINE		
---	LEFT PROPERTY LINE				

**REFERENCES:**

BENCH MARK: CITY 39-831.20

PROFILES BY: \_\_\_\_\_

DRAWINGS: M.D.P.H. PERMIT NO. 700505. 9/14/70

FIELD BOOK: 915

JOB 43-668	DIST. 410	PREPARED BY: _____
JOB _____	DIST. _____	APPROVED BY: _____
JOB _____	DIST. _____	
JOB _____	DIST. _____	



Know what's below.  
Call Before you dig.

REV.	DESCRIPTION	DATE	DRAWN	CHECKED






CITY OF ANN ARBOR  
 PUBLIC SERVICES  
 301 EAST HURON STREET  
 ANN ARBOR, MI 48102-5867  
 www.aaj.gov

PROJECT MANAGEMENT - PUBLIC SERVICES - CITY OF ANN ARBOR  
 2014 SEWER LINING PROJECT  
 SOUTH STATE STREET CROSS LOTS  
 SANITARY SEWER

DRAWING No. 2013019-31  
 SHEET No. 31 OF 51

S:\Project Management\Design\2013019 2014 Sewer Lining Project\Plan Production\Primary\2013019S3.dwg Dwg Created: 5-Feb-14 - \_02 standard bw.stb - Plot Date: 30-Apr-14

NOT SHOWN

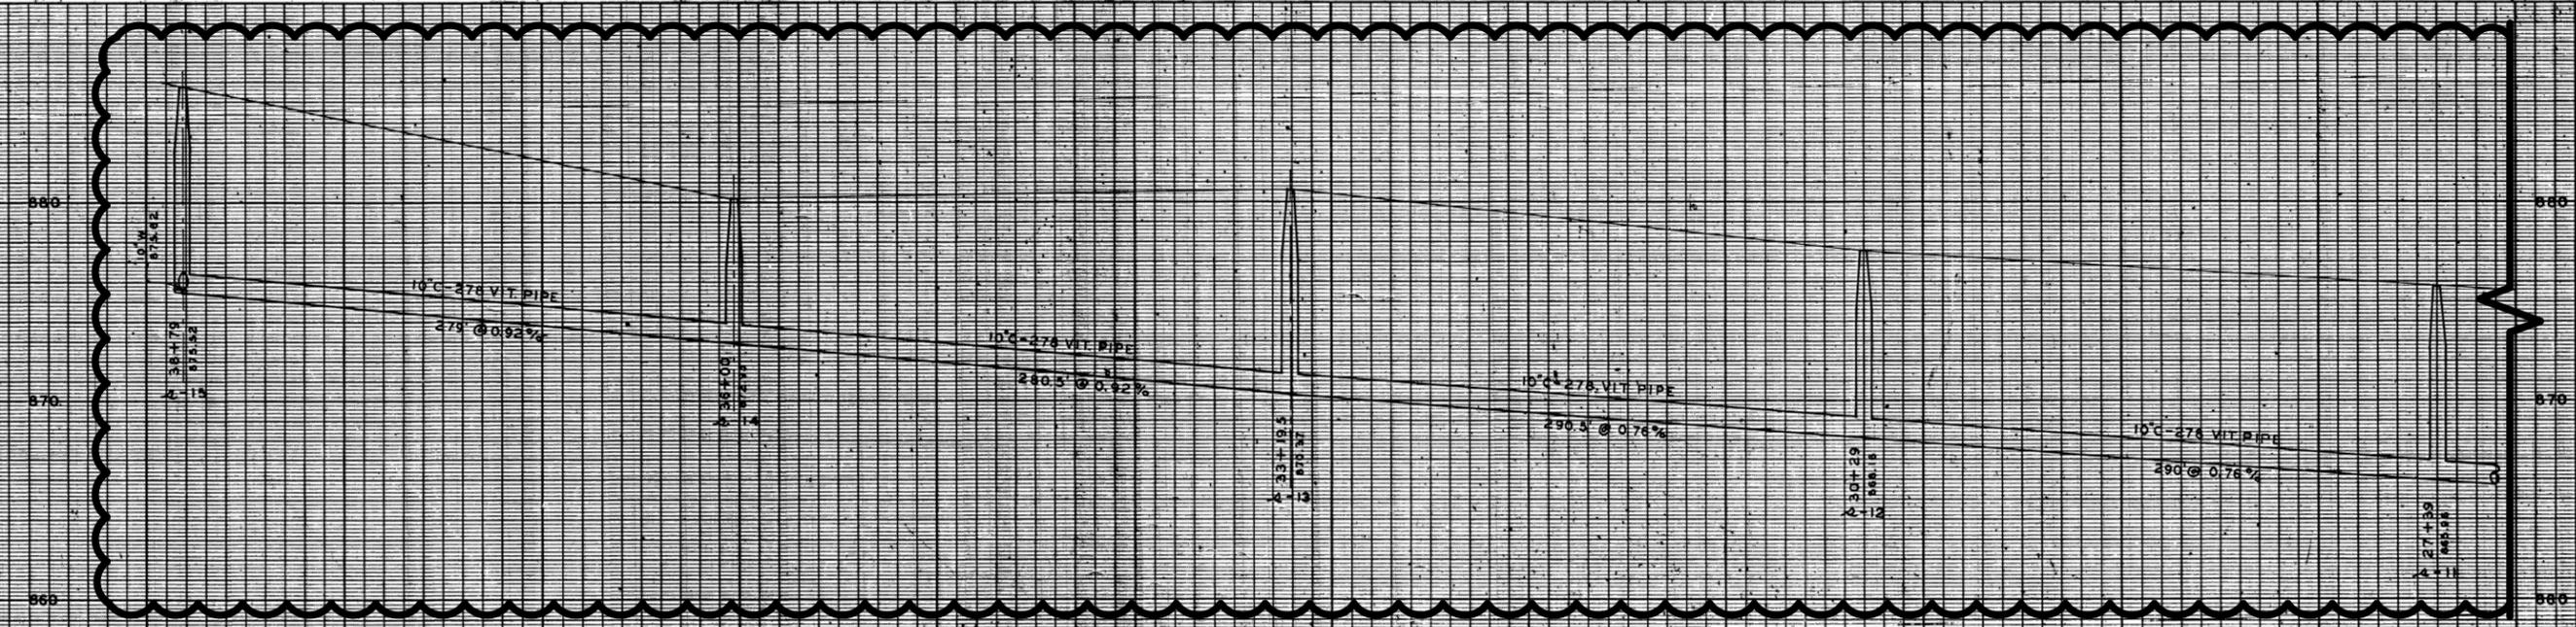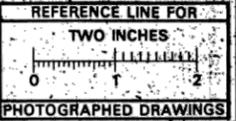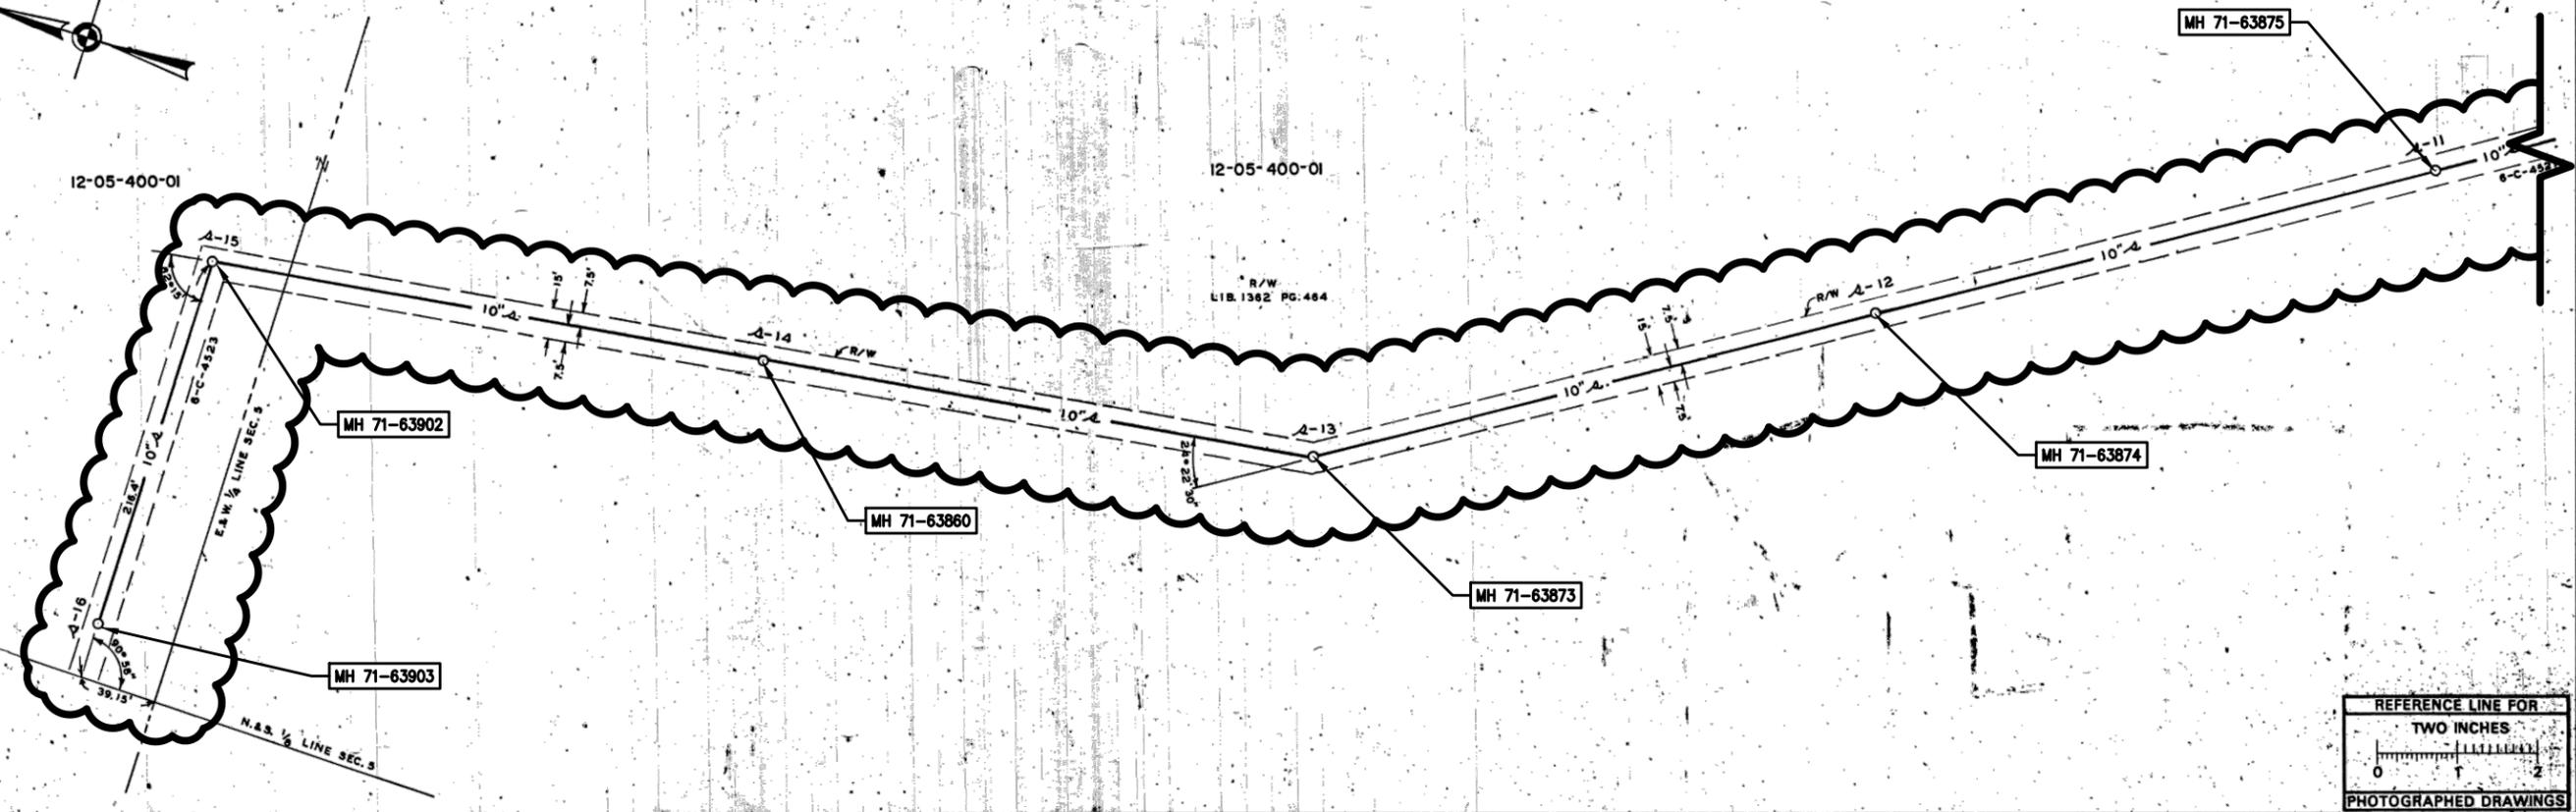

Digital Status  
Scanned On: 6-15-05  
By: DSK  
Dispeckled: YES  
Vectors:  
O.C.R.:

DR. BY 'DON	DATE 12/89	SHEET NO.
TR. BY L.F.S.	1/72	INDEX NO. 6845
CH. BY		SHELF NO.
REVISIONS		
AS BLT. L.F.S.	2/72	

**SANITARY AND STORM SEWER  
CROSSLOTS**  
THRU EDWARDS BROTHERS PROPERTY

SCALE: HORIZONTAL 1" = 40'  
VERTICAL 1" = 4'

FREDRICK A. MAMMEL  
SUPERINTENDENT OF PUBLIC WORKS

**PUBLIC WORKS DEPARTMENT - ANN ARBOR, MICHIGAN**

**LEGEND:**

—○—○—	EXISTING SANITARY	—○—○—	EXISTING STORM	—○—○—	EXISTING GAS
—●—●—	PROPOSED SANITARY	—●—●—	PROPOSED STORM	—●—●—	EXISTING WATER
—○—○—	CENTER LINE	—○—○—	RIGHT PROPERTY LINE	—○—○—	LEFT PROPERTY LINE

**REFERENCES:** BENCH MARK CITY #39-631.20  
DRAWINGS M.D.R.H. PERMIT NO. 700505  
PROFILES BY FIELD BOOK 915  
DATE 9/14/70

JOB 43-568	DIST. 410
JOB	DIST.
JOB	DIST.
JOB	DIST.

PREPARED BY: \_\_\_\_\_  
APPROVED BY: \_\_\_\_\_



REV.	DESCRIPTION	DATE	DRAWN	CHECKED



CITY OF ANN ARBOR  
PUBLIC SERVICE  
301 EAST HURON STREET  
ANN ARBOR, MI 48106-1547  
www.a2gov.org



PROJECT MANAGEMENT - PUBLIC SERVICES - CITY OF ANN ARBOR  
2014 SEWER LINING PROJECT  
SOUTH STATE STREET CROSS LOTS  
SANITARY SEWER

SCALE: NTS  
DRAWING NO. 2013019-32  
SHEET NO. 32 OF 51

S:\Project Management\Design\2013019\2014 Sewer Lining Project\Plan Production\Primary\2013019S3.dwg Dwg Created: 5-Feb-14 - 02 standard bw.stb - Plot Date: 30-Apr-14

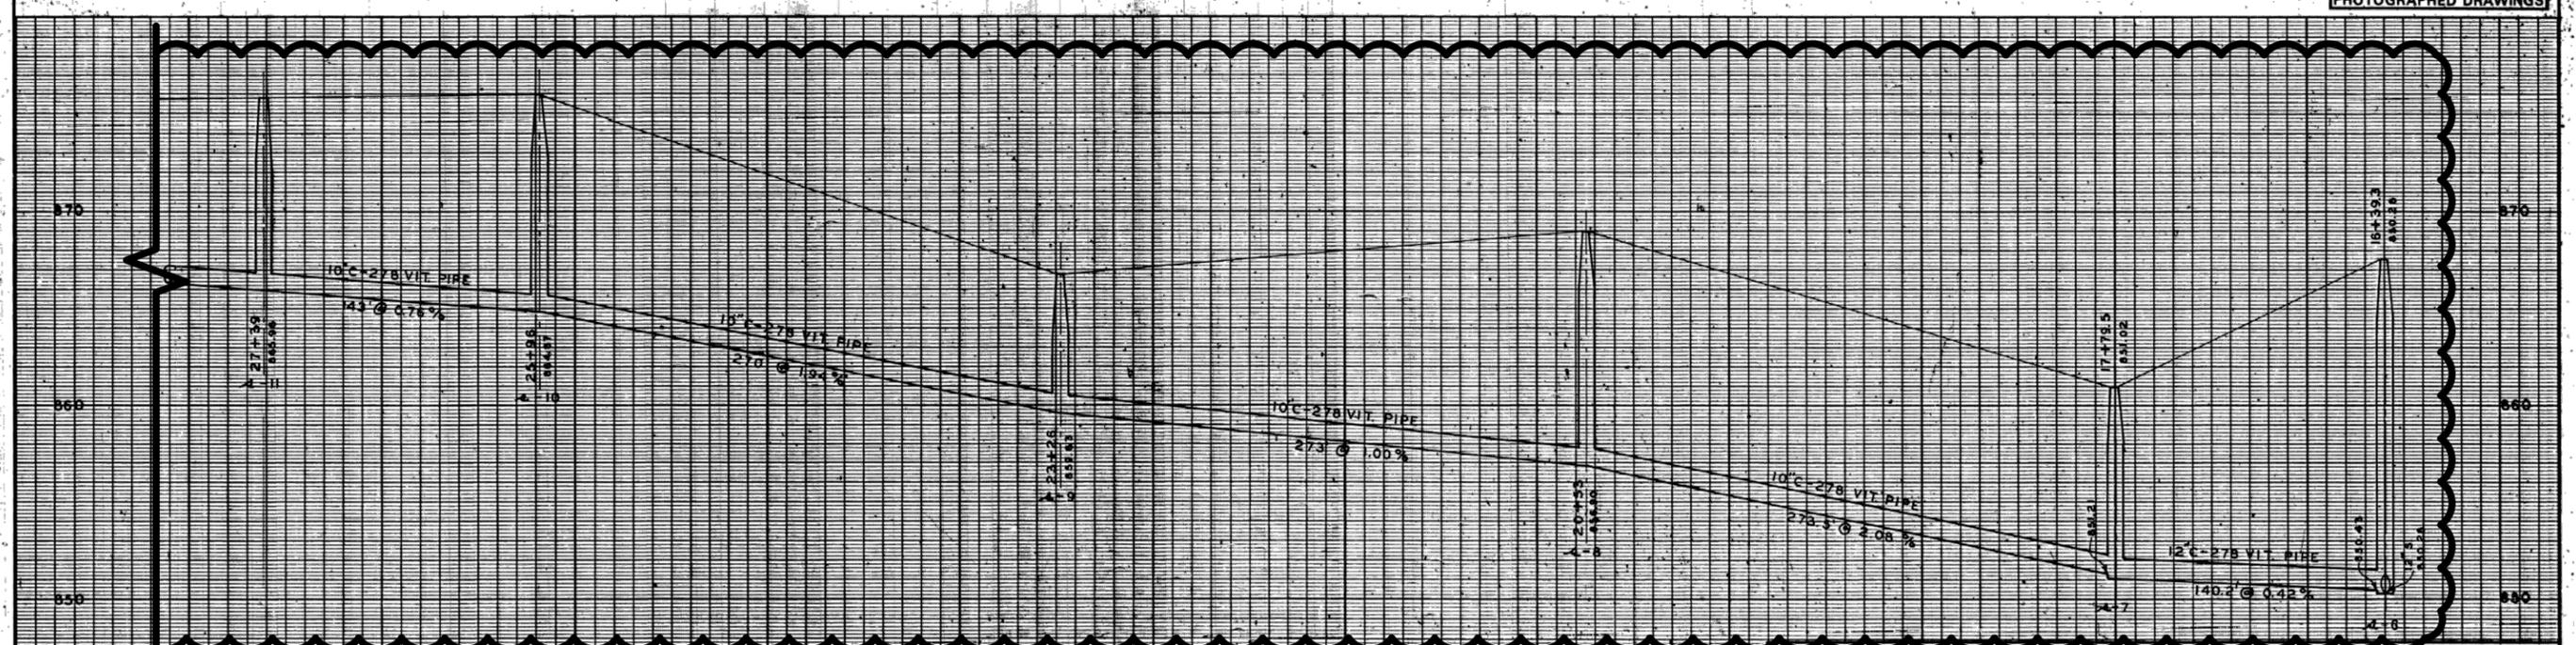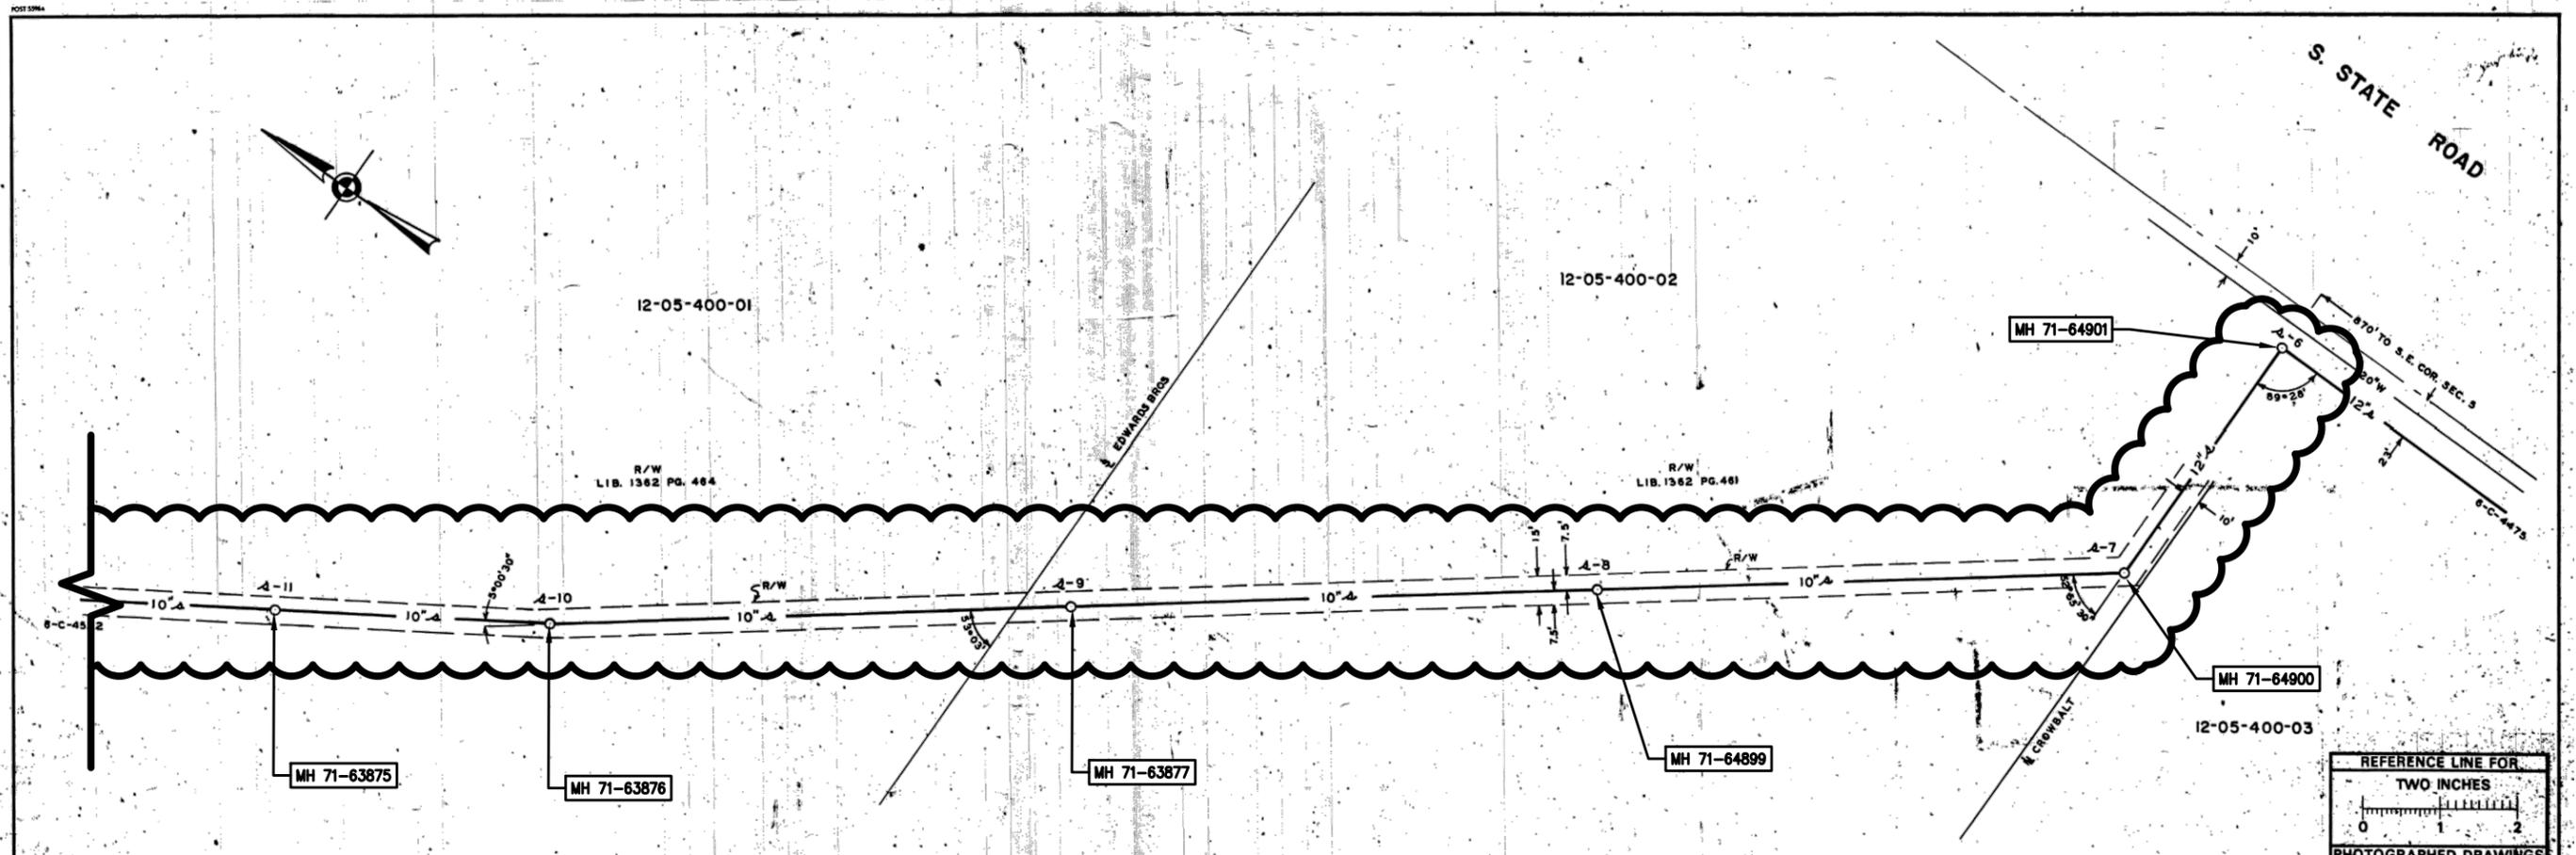

<b>Digital Status</b> Scanned On: 6-15-05 By: DSK Despeckled: YES Vectors: O.C.R.:		DR. BY: DDN 12/09 INDEX NO. 6844 TR. BY: L.F.S. 1/72 SHELF NO. CH. BY: REVISIONS AS BLT. L.F.S. 2/72		6C - 4521 - S SCALE: HORIZONTAL 1"=40' VERTICAL 1"=4'		SANITARY AND STORM SEWER <b>CROSSLOTS</b> S. STATE TO 1200 FT. NW'LY. FREDRICK A. MAMMEL SUPERINTENDENT OF PUBLIC WORKS			
<b>LEGEND:</b> UNDERGROUND UTILITIES PROFILES ○—○ EXISTING SANITARY ●—● PROPOSED SANITARY ○—○ EXISTING STORM ●—● PROPOSED STORM — G — EXISTING GAS — W — EXISTING WATER ——— CENTER LINE - - - - - LEFT PROPERTY LINE - - - - - RIGHT PROPERTY LINE				<b>REFERENCES:</b> BENCH MARK CITY # 39-831.20 DRAWINGS M.D.R.H. PERMIT NO. 700505 PROFILES BY FIELD BOOK 915 9/14/70				PUBLIC WORKS DEPARTMENT — ANN ARBOR, MICHIGAN JOB 43-688 SAN. DIST. 410 JOB DIST. JOB DIST. PREPARED BY APPROVED BY	

CITY OF ANN ARBOR  
 PUBLIC SERVICES  
 301 EAST HURON STREET  
 ANN ARBOR, MI 48102-3847  
 WWW.ANARBOR.MI.GOV

REV.	DESCRIPTION	DATE	DRAWN	CHECKED

PROJECT MANAGEMENT - PUBLIC SERVICES - CITY OF ANN ARBOR  
 2014 SEWER LINING PROJECT  
 SOUTH STATE STREET CROSSLOTS  
 SANITARY SEWER

SHEET No. 33 OF 51  
 DRAWING No. 2013019-33



MH 71-67701 TO MH 71-67699  
LINE 398 LF OF 10 INCH VCP  
WITH CIPP LINER

MH 71-67701

MH 71-67700

MH 71-67699

CITY OF ANN ARBOR PUBLIC SERVICE 301 EAST HURON STREET ANN ARBOR MI 48106-1647 www.a2gov.org	CITY OF ANN ARBOR PUBLIC SERVICES - CITY OF ANN ARBOR 2014 SEWER LINING PROJECT MILLER AVENUE SANITARY SEWER
SCALE: NTS DRAWING No. 2013019-34A	SHEET No. 34A OF 51
REV.	DESCRIPTION DATE DRAWN CHECKED





**PROJECT MANAGEMENT - PUBLIC SERVICES - CITY OF ANN ARBOR**  
 2014 SEWER LINING PROJECT  
 PINEVIEW COURT  
 SANITARY SEWER

SCALE: NTS  
 DRAWING No. 2013019-35A

SHEET No. 35A OF 51



**811**  
 Know what's below.  
 Call before you dig.

CITY OF ANN ARBOR  
 PUBLIC SERVICE  
 301 EAST HURON STREET  
 ANN ARBOR, MI 48106-0647  
 ANN ARBOR 734-794-4410  
 www.a2gov.org

CITY OF ANN ARBOR  
 PUBLIC SERVICE

REV.	DESCRIPTION	DATE	DRAWN	CHECKED

S:\Project Management\Design\2013019 2014 Sewer Lining Project\Plan Production\Primary\2013019S3.dwg Dwg Created: 5-Feb-14 - \_o2 standard bw.stb - Plot Date: 30-Apr-14

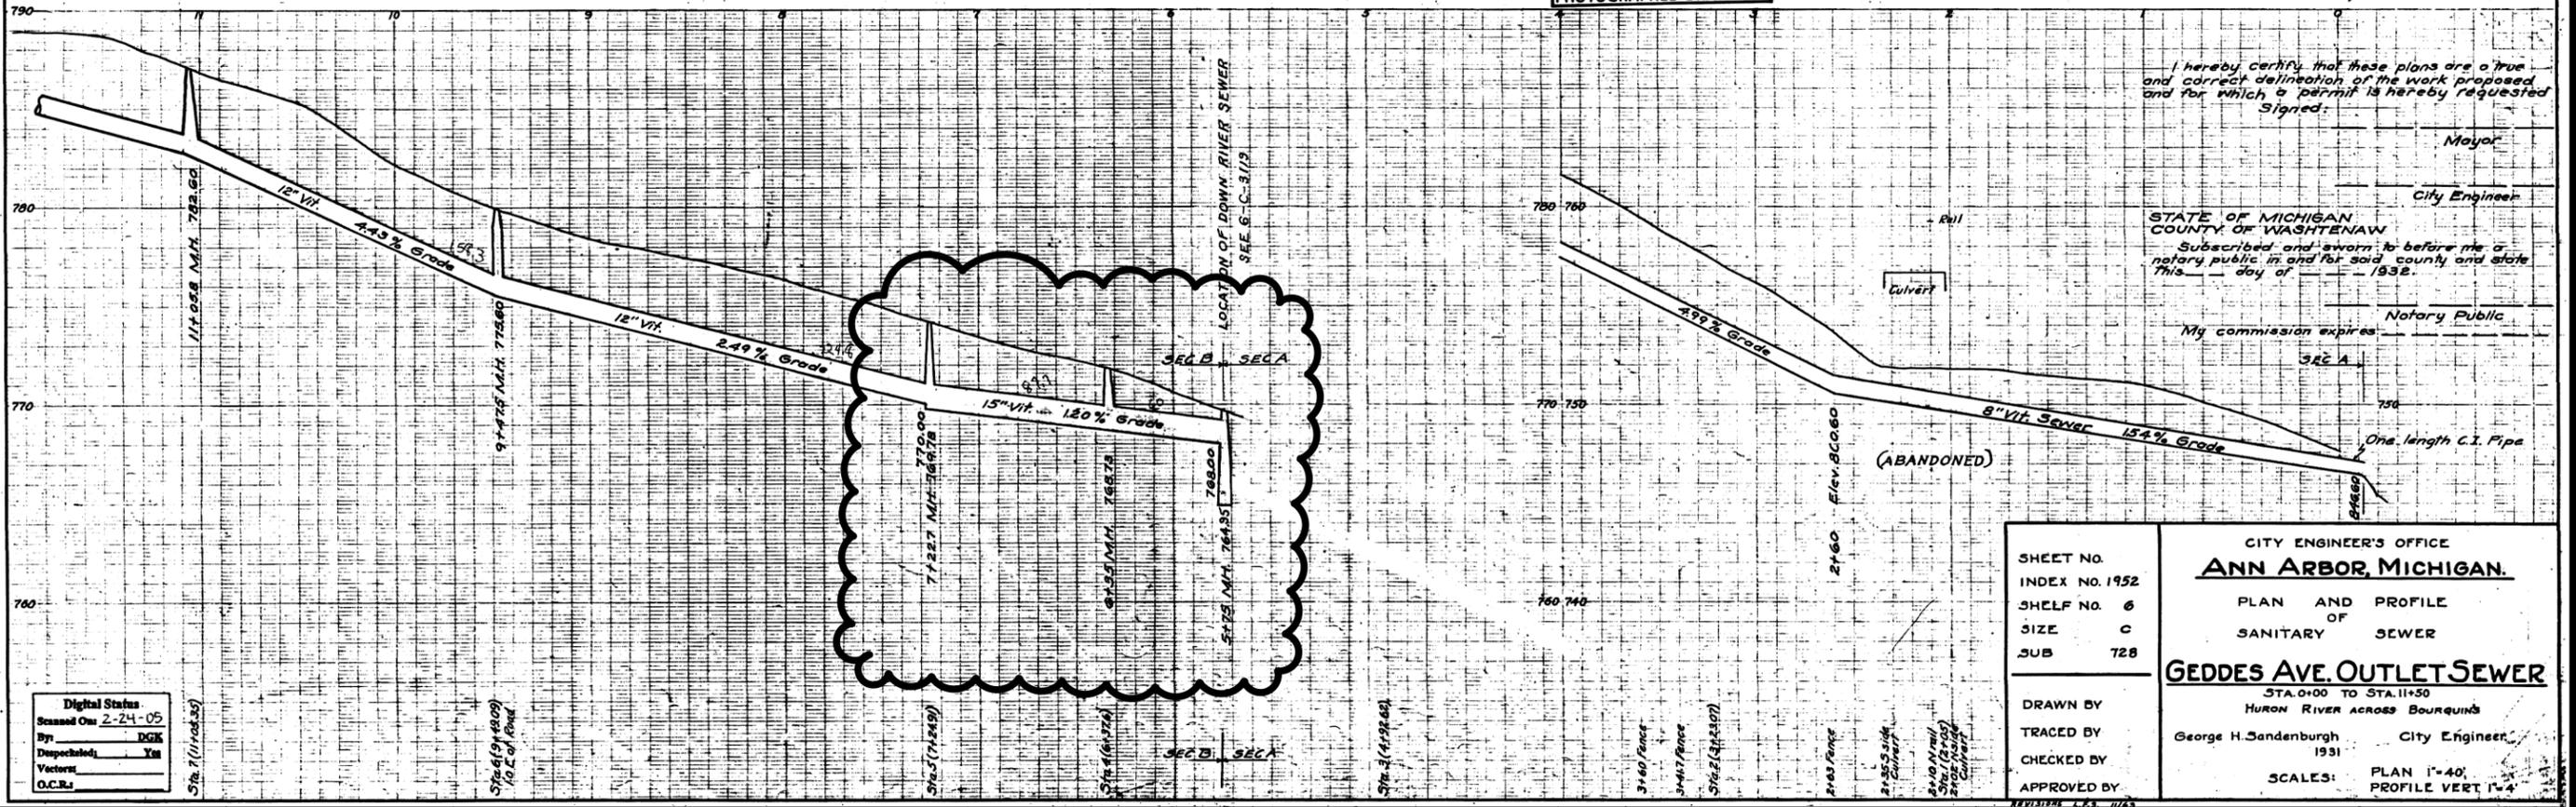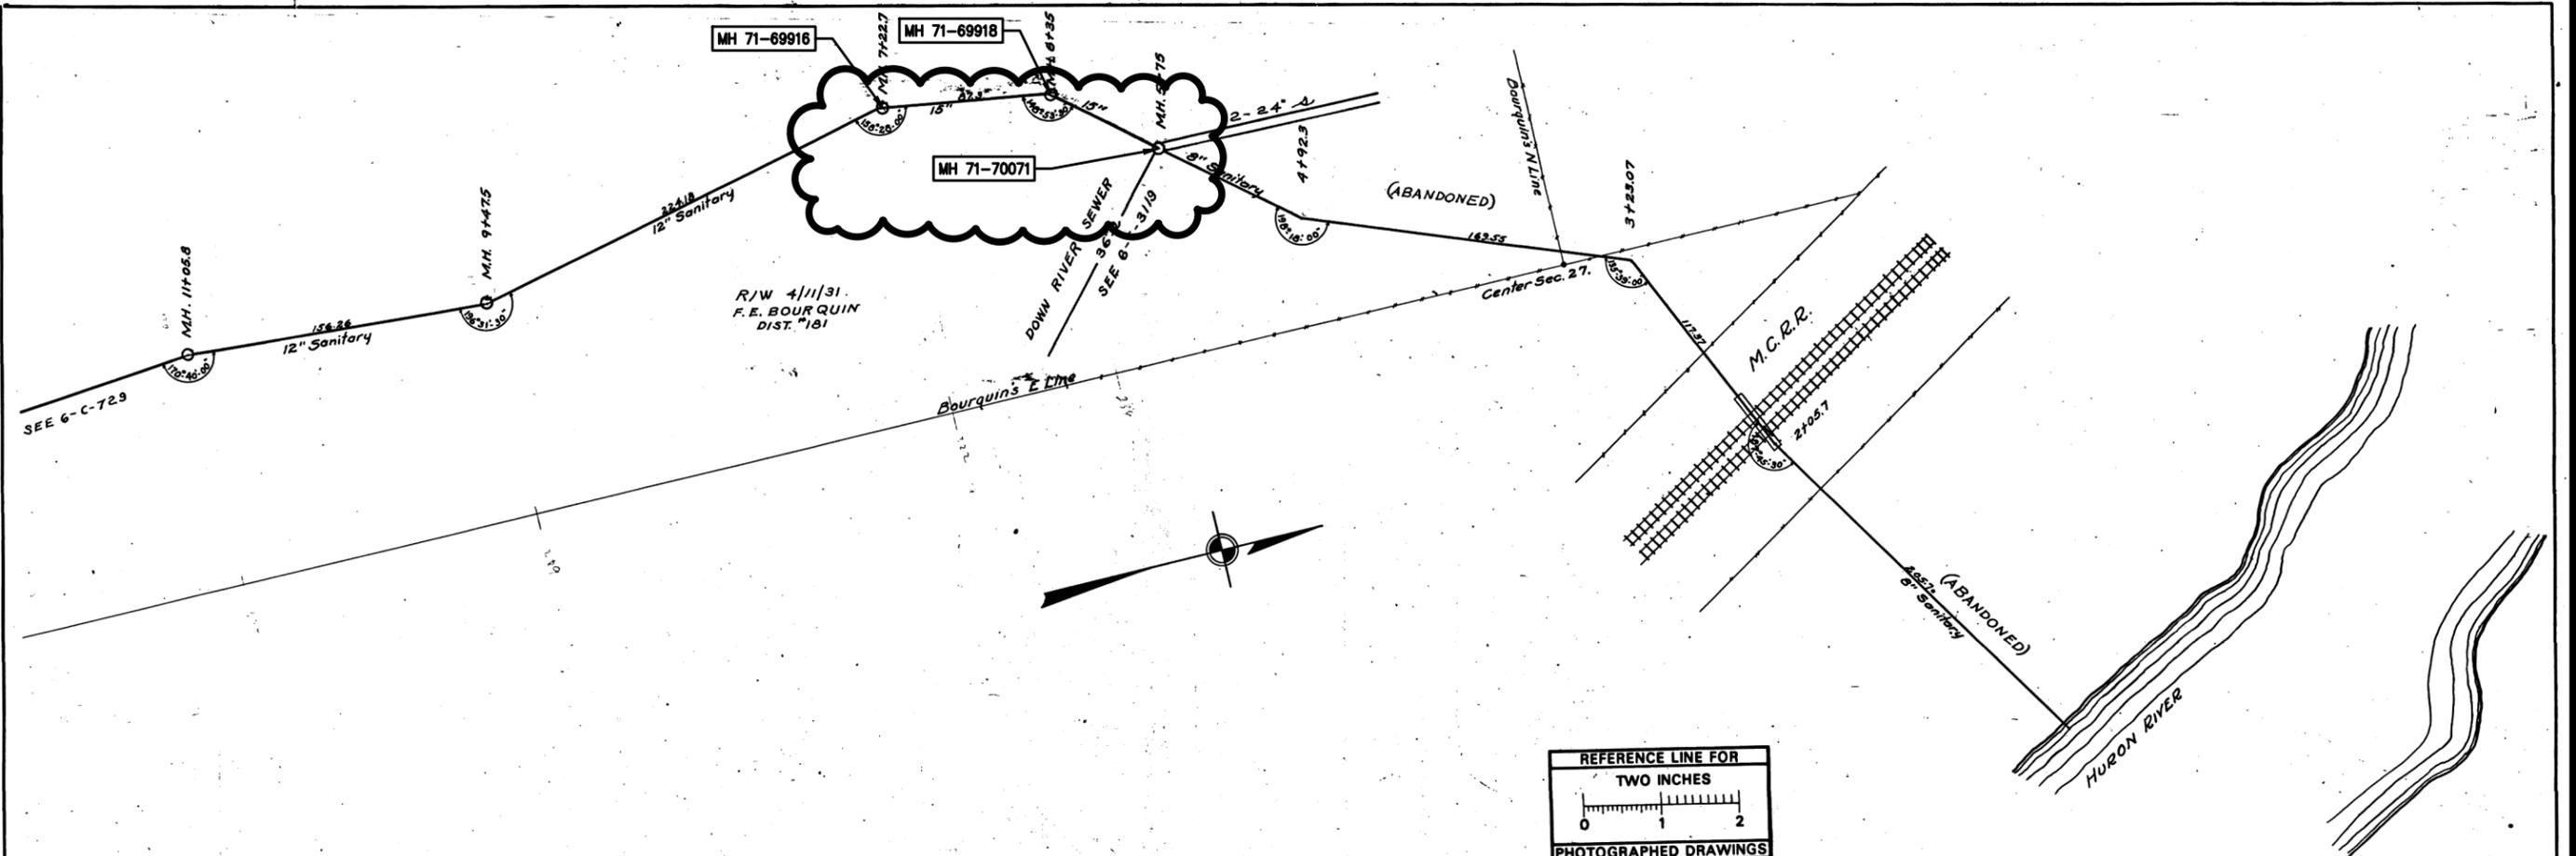

Digital Status  
 Scanned On 2-24-05  
 By DGM  
 Despatched Yes  
 Vectors  
 O.C.R.

SHEET NO.  
 INDEX NO. 1952  
 SHELF NO. 6  
 SIZE C  
 SUB 728

CITY ENGINEER'S OFFICE  
**ANN ARBOR, MICHIGAN.**  
 PLAN AND PROFILE  
 OF  
 SANITARY SEWER  
**GEDDES AVE. OUTLET SEWER**  
 STA. 0+00 TO STA. 11+50  
 HURON RIVER ACROSS BOURQUIN'S  
 George H. Sandenburgh 1931 City Engineer  
 SCALES: PLAN 1"=40'  
 PROFILE VERT 1"=4'

PROJECT MANAGEMENT - PUBLIC SERVICES - CITY OF ANN ARBOR  
 2014 SEWER LINING PROJECT  
 PINEVIEW COURT  
 SANITARY SEWER

SCALE: NTS  
 DRAWING NO. 2013019-35  
 SHEET NO. 35 OF 51

REV.	DESCRIPTION	DATE	DRAWN	CHECKED

City of Ann Arbor Public Services  
 301 East Huron Street  
 Ann Arbor, MI 48106-1500  
 www.a2gov.org



CITY OF ANN ARBOR  
PUBLIC SERVICE  
301 EAST HURON STREET  
ANN ARBOR, MI 48106-1667  
www.a2gov.org

REV.	DESCRIPTION	DATE	DRAWN	CHECKED



